

DESIGNED \_\_\_\_\_  
 DRAWN GDC  
 CHECKED \_\_\_\_\_  
 APPROVED BY \_\_\_\_\_

NO.	REVISION	DATE	BY	APP'D




2925 NE 85th AVE  
 Portland, OR 97213  
 P. 503.941.5566  
 WWW.CDGPORLAND.COM

**SKYLINE COLLEGE  
 THEATRE DECK PLAN**

DATE 04-02-2011  
 SCALE 3/8"=1'-0"

**LIGHTING PLAN**

JOB NUMBER **SO2-011-01**  
 SHEET NAME: LIGHTING PLAN  
 SHEET **2** OF **5**

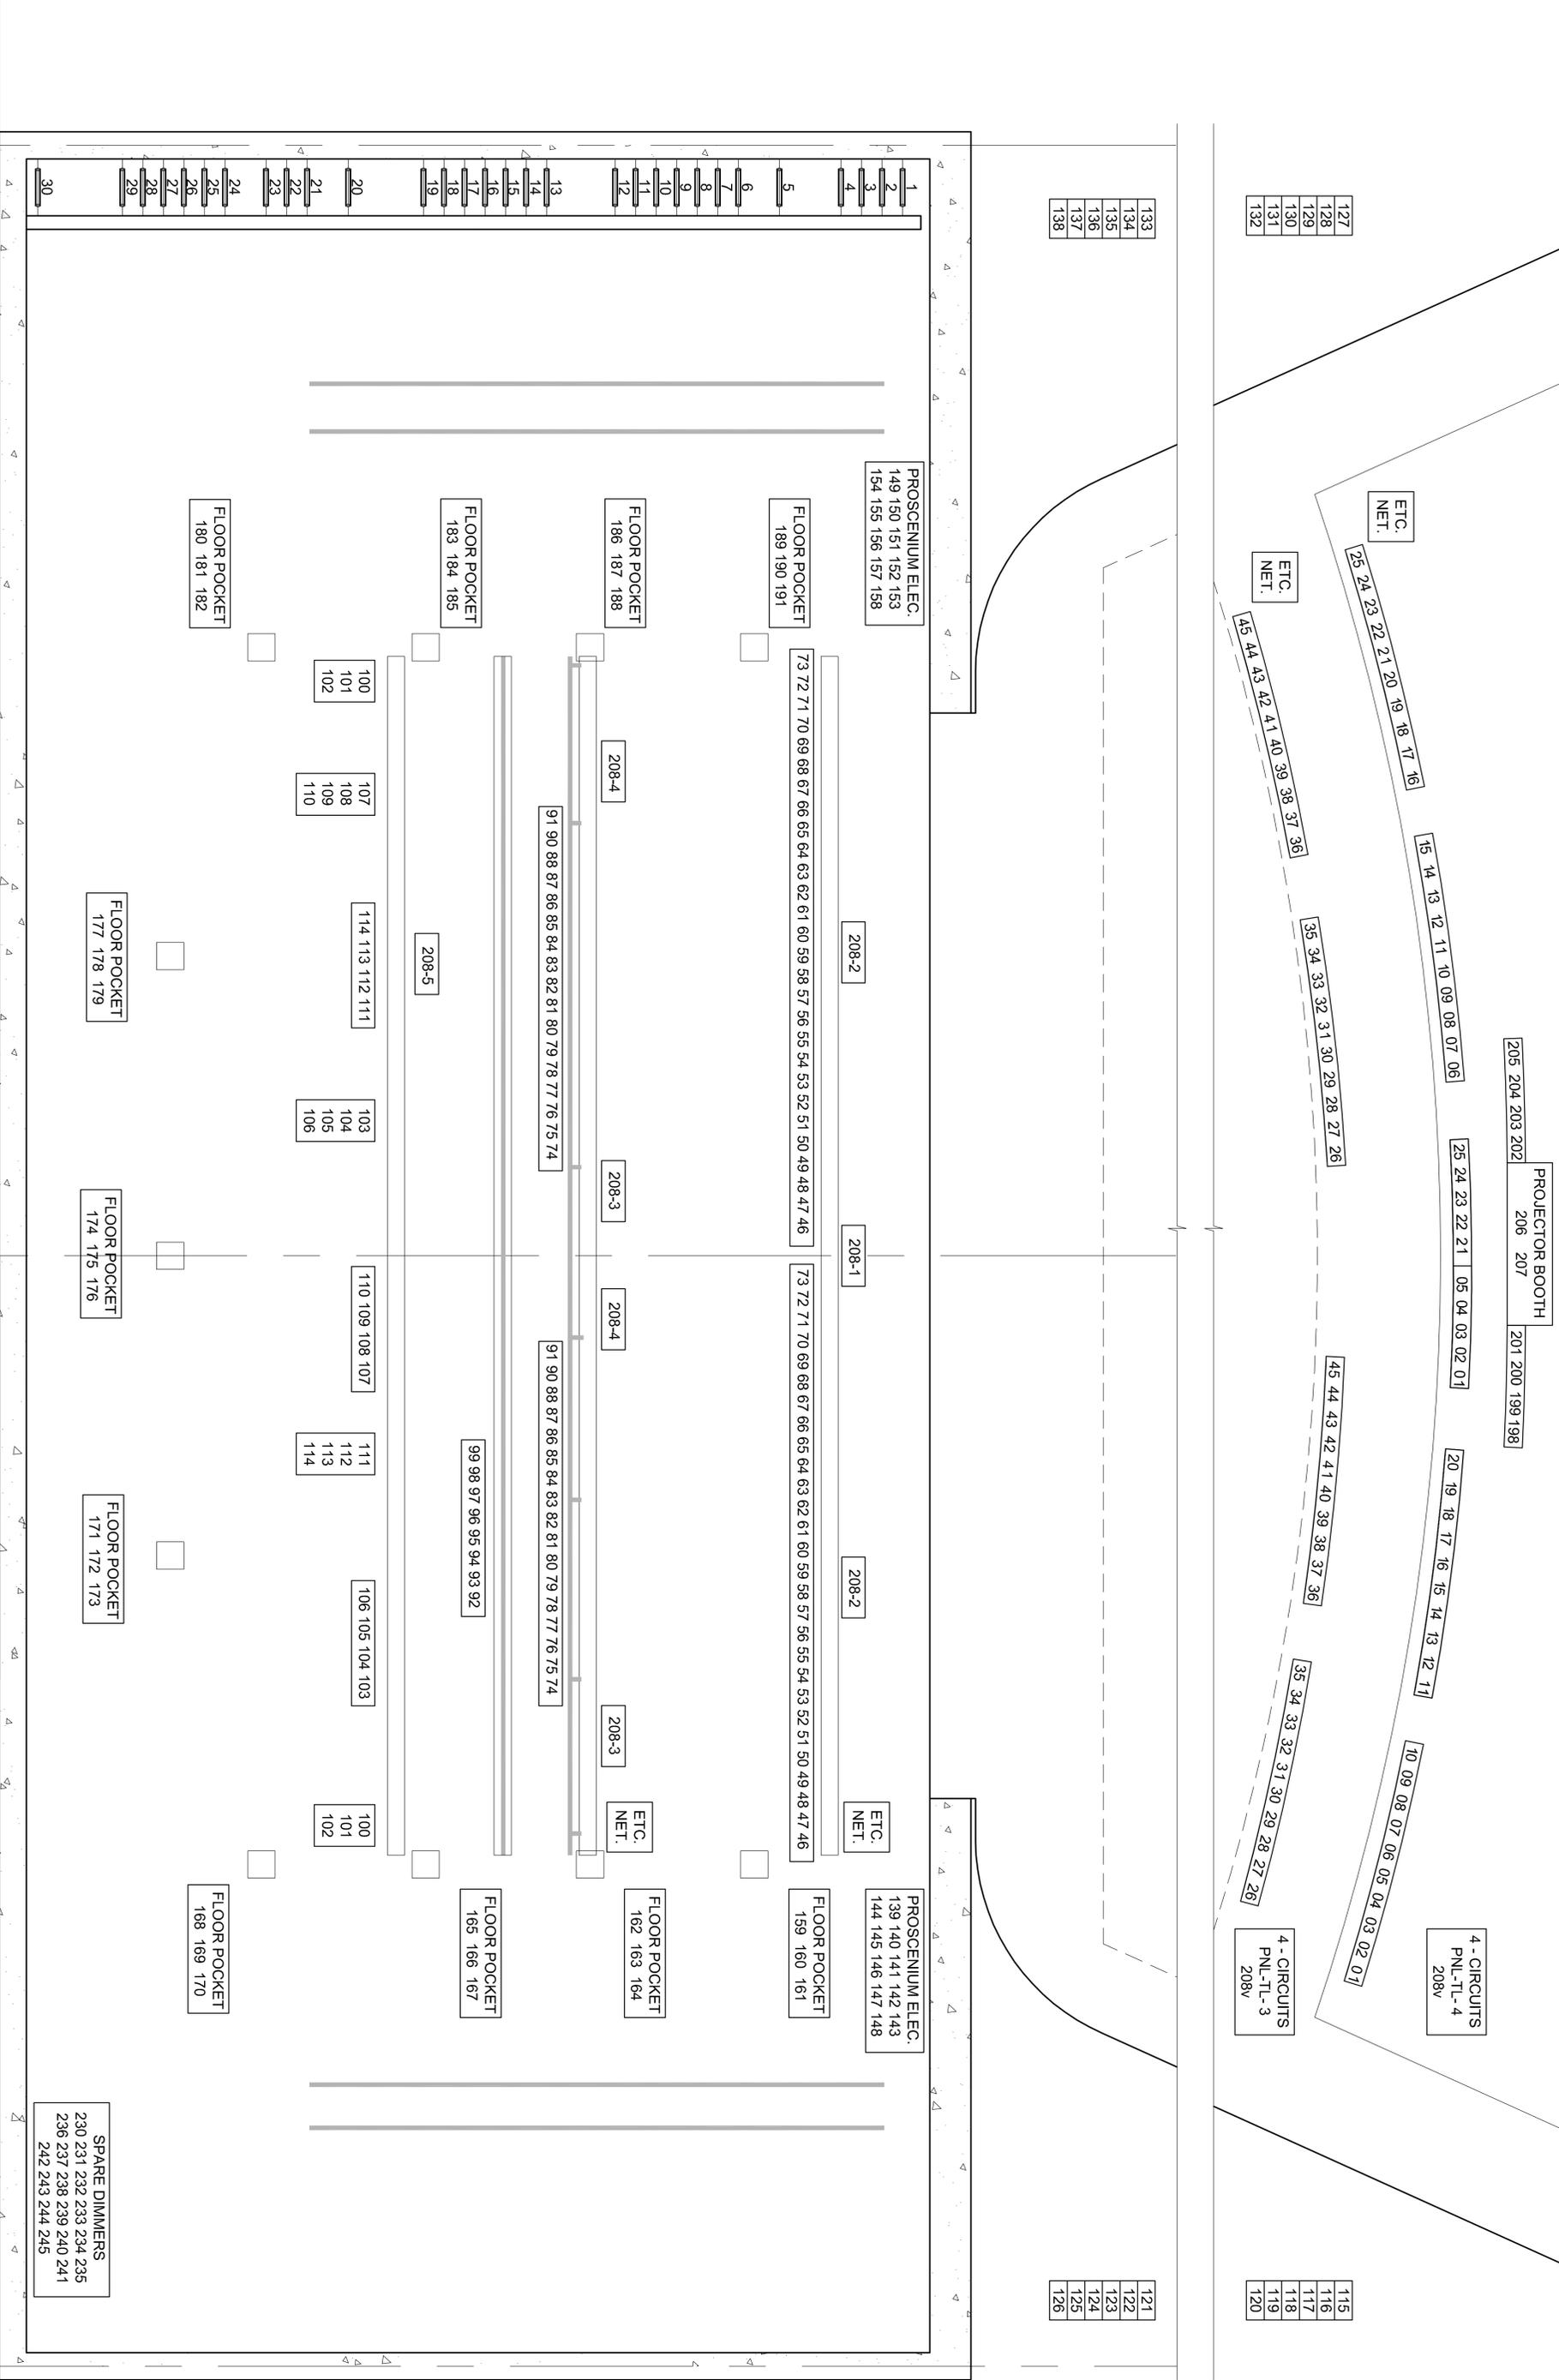

133  
134  
135  
136  
137  
138

127  
128  
129  
130  
131  
132

115  
116  
117  
118  
119  
120

121  
122  
123  
124  
125  
126